


PROPOSED ELEVATED PLATFORM FOR WIRELESS CARRIERS

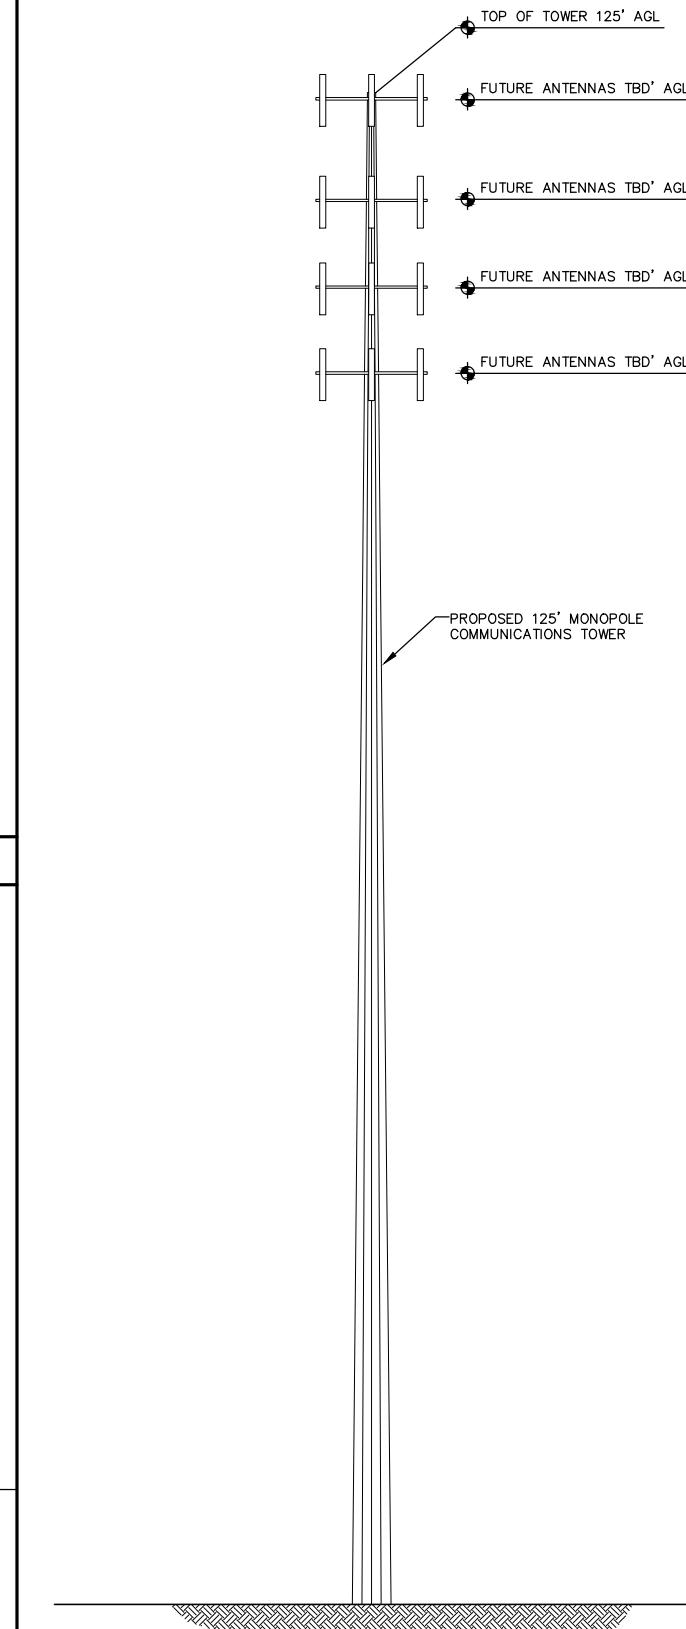

PROPOSED TOWER ELEVATION

PROPOSED ELEVATED PLATFORM FOR WIRELESS CARRIERS

PROPOSED SITE PLAN-KEYS WEST TELCO-AMERICAN LEGION POST #28, 5610 COLLEGE ROAD, KEY WEST, FL

| | | |
|--|----------------|-----------------|
| APPLICANT/OWNER: | | |
|  KEY WEST TELCO, LLC | | |
| P.O. BOX 999 TAVERNIER, FL 33070 305-852-8171 | | |
| PROJECT NAME AND LOCATION: | | |
| AMERICAN LEGION POST 28 5610 COLLEGE ROAD KEY WEST, FLORIDA 33040 | | |
| PROJECT ENGINEER | | |
| 2° | 10° | WAYPOINT |
| ENGINEERING AND EQUIPMENT LLC INDIANTOWN ROAD, SUITE 105 LAKELAND, FLORIDA 33845 PHONE: 561-252-1220 FAX: 561-252-1220 E-MAIL: DA#29673 | | |
| ENGINEER SEAL | | |
|  | | |
| RUSSELL C. MORRISON, P.E. FLORIDA P.E. #51567 | | |
| DATE OF ISSUE | | |
| OCTOBER 4, 2018 | | |
| ISSUED FOR | | |
| ZONING DOCUMENT | | |
| SUBMITTALS | | |
| DATE | DESCRIPTION | |
| | | |
| | | |
| | | |
| | | |
| | | |
| | | |
| PROJECT NUMBER | | |
| L201805-06 | | |
| BY | | |
| BY | CHECKED | APPROVED |
| RCM | RCM | RCM |
| APPROVING AGENCY | | |
| KEY WEST, FLORIDA | | |
| BUILDING CODE | | |
| 2017 FLORIDA BUILDING CODE | | |
| SHEET TITLE | | |
| SITE PLAN | | |
| SHEET NUMBER | | |
| Z-2 | | |